BUILDING SITE INFORMATION	
ADDRESS	
808 CANADA GAMES WAY, PRINCE GEORGE, BC.	

BUILDING ENERGY - MECHANICAL	
HVAC DESIGN	
ENERGY STANDARD/CODE	ASHRAE 90.1-2016
COMPLIANCE PATH	PRESCRIPTIVE
DESIGN METHOD	MANDATORY PROVISIONS & PRESCRIPTIVE
IN ACCORDANCE WITH	SECTION 6
CLIMATE ZONE	7
VENTILATION	ASHRAE 62.1-2001 (EXCEPT ADDENDUM N)


## **GENERAL NOTES:**


- 1. INSTALLATIONS SHALL BE IN ACCORDANCE WITH THE BRITISH COLUMBIA BUILDING CODE 2018, BRITISH COLUMBIA PLUMBING CODE 2018, LOCAL BUILDING BYLAWS, MUNICIPAL GUIDELINES AND REQUIREMENTS WHERE APPLICABLE.
- MECHANICAL SERVICES ARE SCHEMATIC REPRESENTATION ONLY. MECHANICAL CONTRACTOR SHALL FIELD MEASURE ALL MATERIAL PRIOR TO INSTALLATION. PROVIDE OFFSETS WHERE NECESSARY TO AVOID CONFLICT WITH STRUCTURAL AND ALL OTHER TRADES.

## FIRE PROTECTION NOTES:

- 1. BUILDING SPRINKLERED TO NFPA-13, LIGHT HAZARD OCCUPANCY.
- 2. THESE DOCUMENTS ARE TO PROVIDE PERFORMANCE SPECIFICATION ONLY. CONTRACTOR SHALL RETAIN A SEPARATE FIRE PROTECTION ENGINEER REGISTERED IN THE PROVINCE OF BRITISH COLUMBIA TO PERFORM DETAILED SPRINKLER DESIGN AND HYDRAULIC CALCULATIONS. THESE DRAWINGS SHALL BE SEALED AND SIGNED COMPLETE WITH LETTERS OF ASSURANCE SCHEDULE.
- SHOP DRAWINGS AND HYDRAULIC CALCULATIONS TO BE REVIEWED BY THE SEPARATE FIRE PROTECTION ENGINEER AND SUBMITTED TO THE MECHANICAL CONSULTANT FOR REVIEW PRIOR TO INSTALLATION.
- 4. ALL SPRINKLER PIPING IS TO BE COORDINATED WITH CEILING SPACE, STRUCTURAL WORK, AND OTHER TRADES.

		SYMBOL SCHEDU	LE
NEW	EXISTING	DEMOLITION	
			SUPPLY OR OUTDOOR AIR DUCT UP
CZJ	CZ3	<b>C</b> \$4	SUPPLY OR OUTDOOR AIR DUCT DOWN
			RETURN AIR DUCT UP
[2]	[5]	<i>521</i>	RETURN AIR DUCT DOWN
#	#		BALANCING DAMPER
	$\rightrightarrows \rightarrow$	<del></del>	DUCT OR PIPE CAP-OFF
			SUPPLY AIR DIFFUSER
$\boxtimes$			SUPPLY AIR GRILLE
			EXHAUST AIR GRILLE
			RETURN AIR GRILLE
——— HWS ———	——————————————————————————————————————	<del>/////</del> /XV\$/ <del>/////</del> /	HEATING WATER SUPPLY
HWR		'++++/\\\\\\\\\\\\\\\\\\\\\\\\\\\\\\\\\	HEATING WATER RETURN
		' <del>/////</del> //	DOMESTIC COLD WATER ( DCW )
	•••	' <del>/////</del> '/ <del>/////</del> /	DOMESTIC HOT WATER ( DHW )
	•••	' <del>/////</del> /'/////	DOMESTIC HOT WATER RECIRC. ( DHWR )
v	v	4HHHNHHH	SANITARY VENT
		<del>/////////////////////////////////////</del>	SANITARY SEWER ABOVE GRADE
		<del>/////////////////////////////////////</del>	SANITARY SEWER BELOW GRADE
<del></del>		<del>//////*//////////////////////////////</del>	DIRECTION OF FLOW
<del></del>	<del></del>	<del>//////</del> y	PIPE DROP
		<del>//////</del>	PIPE RISE
<del></del>		' <del>////////////////////////////////////</del>	2-WAY CONTROL VALVE
	<b></b>	<i>/////////////////////////////////////</i>	BALANCING VALVE
		' <del>/////<b>!</b>Ø//////</del> /	PENDANT SPRINKLER HEAD
<del></del>	<u> </u>	' <del>/////\Ø//////</del> /	UPRIGHT SPRINKLER HEAD
	-		GRILLE TYPE NECK / GRILLE SIZE AIR VOLUME (L/s)
-	-	-	EQUIPMENT / FIXTURE TYPE

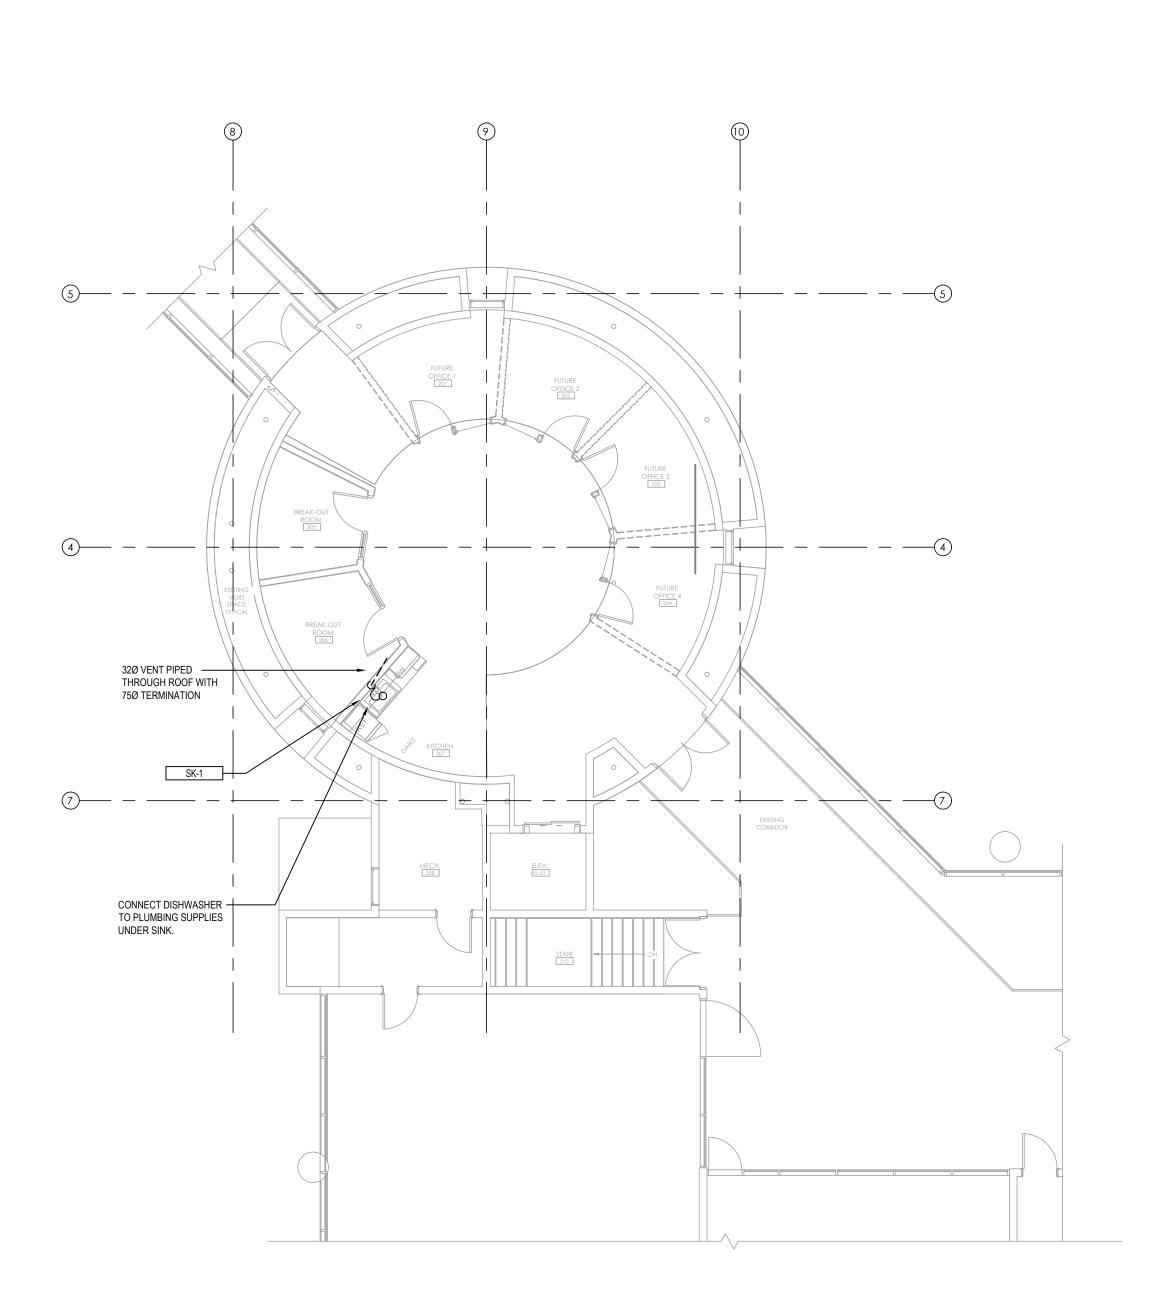

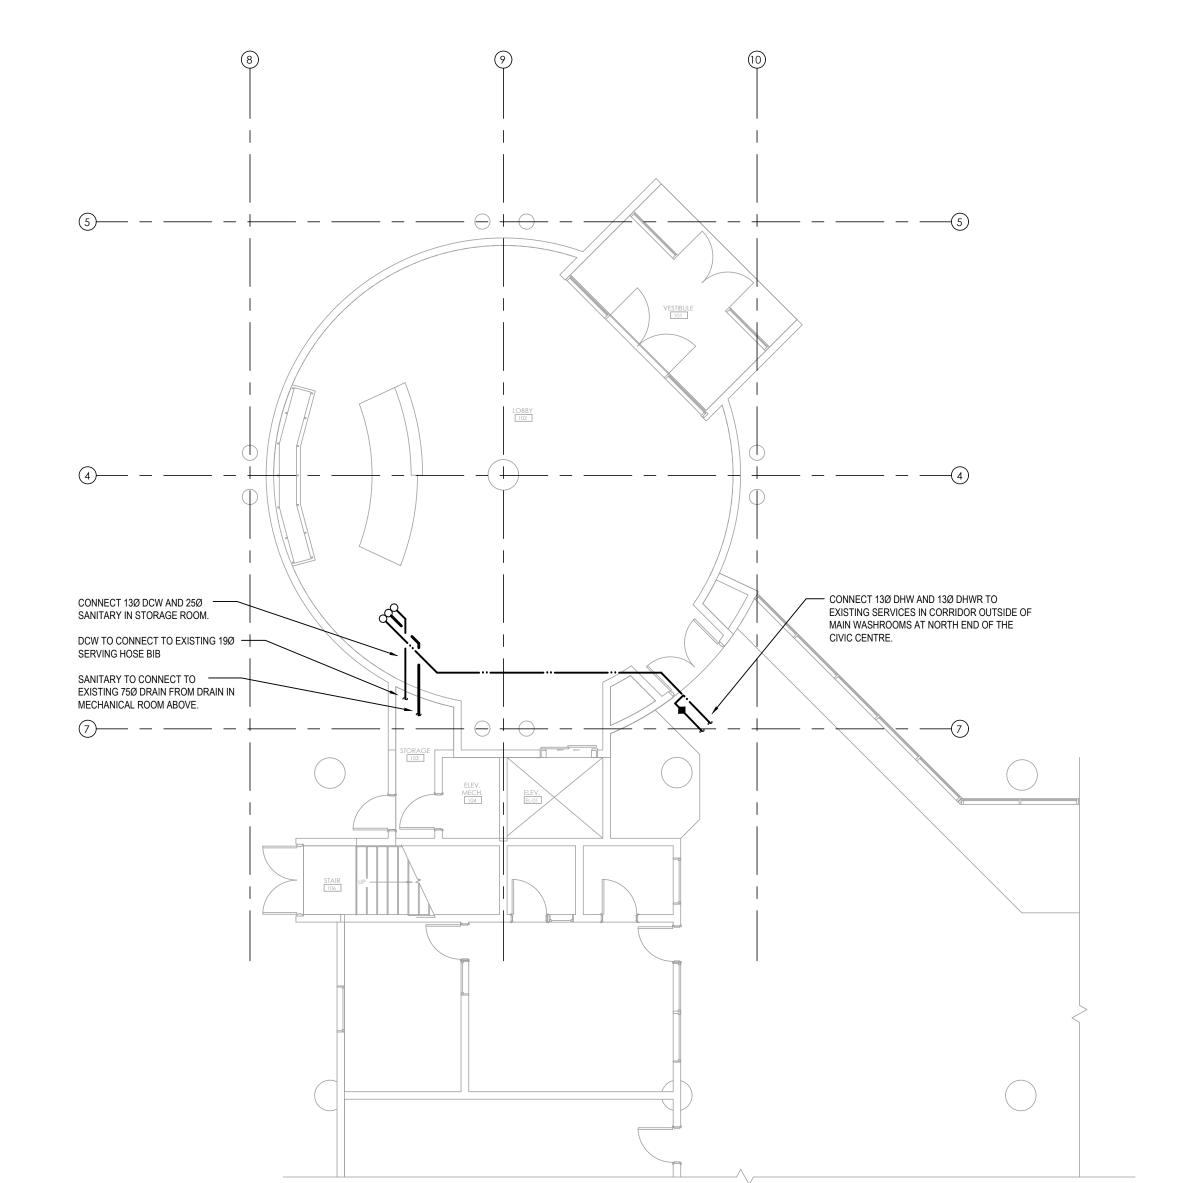







ROCKY POINT
ENGINEERINGLTD.
Vancouver • Langley • Victoria • Nanaimo • Kelowna • Kamloops • Nelson • Smithers





This drawing is the property of the Architect and unauthorized reproduction is prohibited under the Copyright Act.
Electronic files when provided are instruments of service and the sole property of Sahuri + partners architecture inc. No alteration or reproduction shall be made without written authorization from Sahuri + partners architecture inc.
The Contractor shall check and verify all dimensions and report any discrepancies to the Architect prior to construction; do not scale this drawing.
This drawing shall not be used for construction unless properly noted as 'ISSUED FOR CONSTRUCTION' by the Architect.

All dimensions are in millimeters unless noted otherwise.

ISSUES/REVISIONS

DATE DESCRIPTION #

2024-02-22 ISSUED FOR TENDER 1

Seal



Client







Project Title
PG TOURISM OFFICE
808 CANADA GAMES WAY,
PRINCE GEORGE

Drawing Title
MAIN & SECOND FLOOR
PLUMBING PLAN

Drawing info
Scale 1:100 24030-T

Date 2023-12-21
Drawn CL
Checked CL
Partner CL

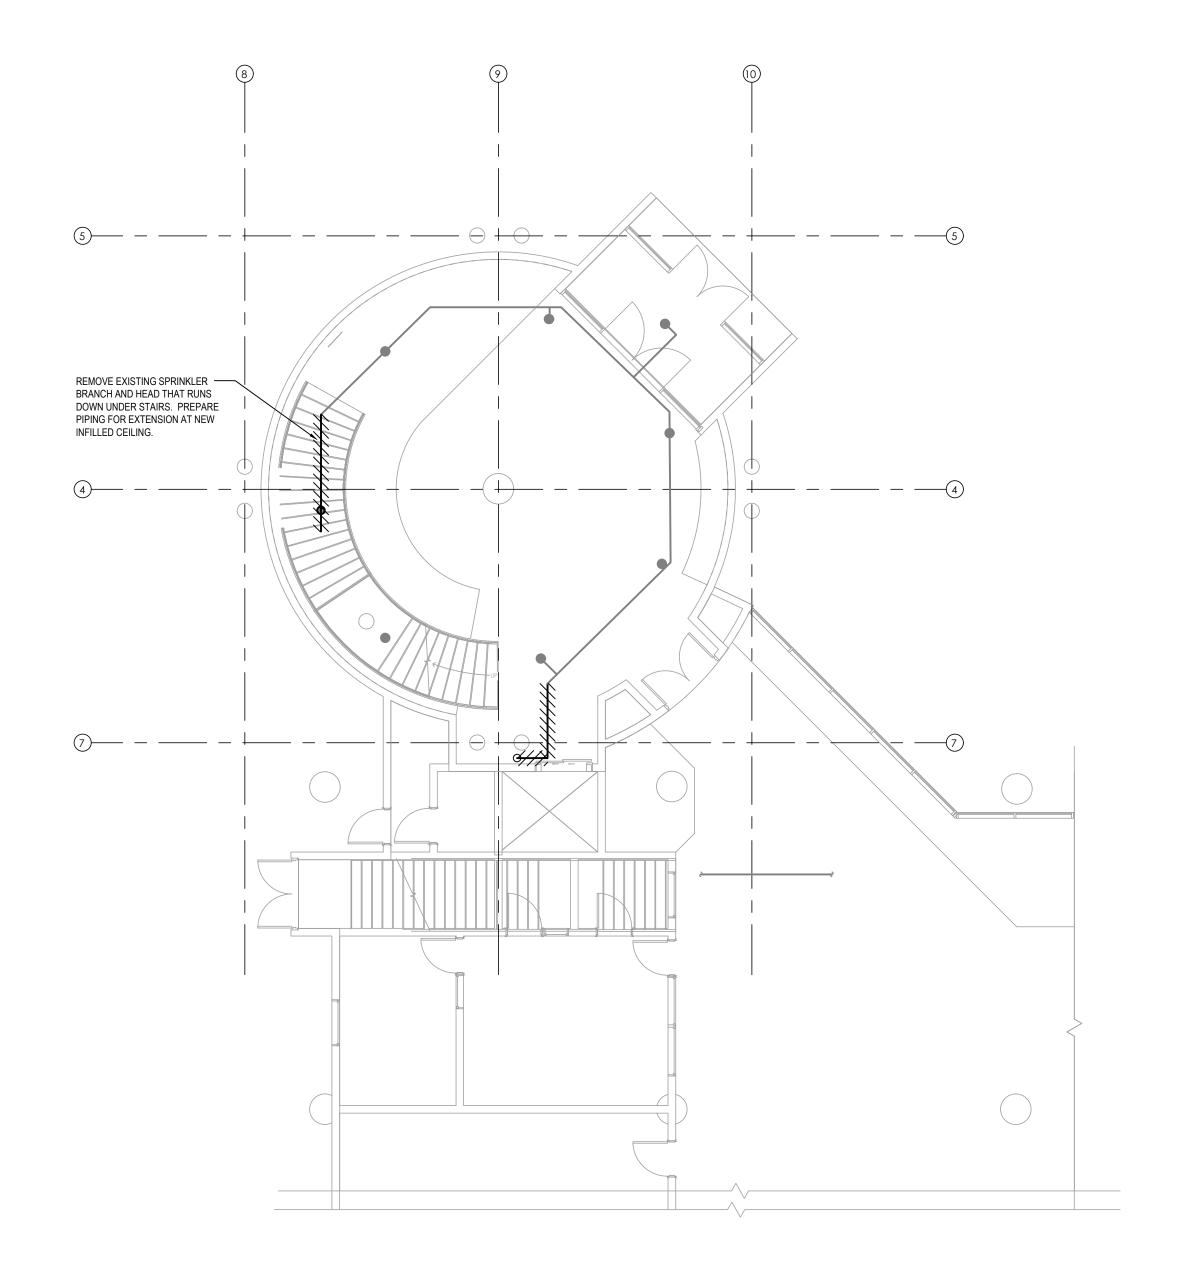

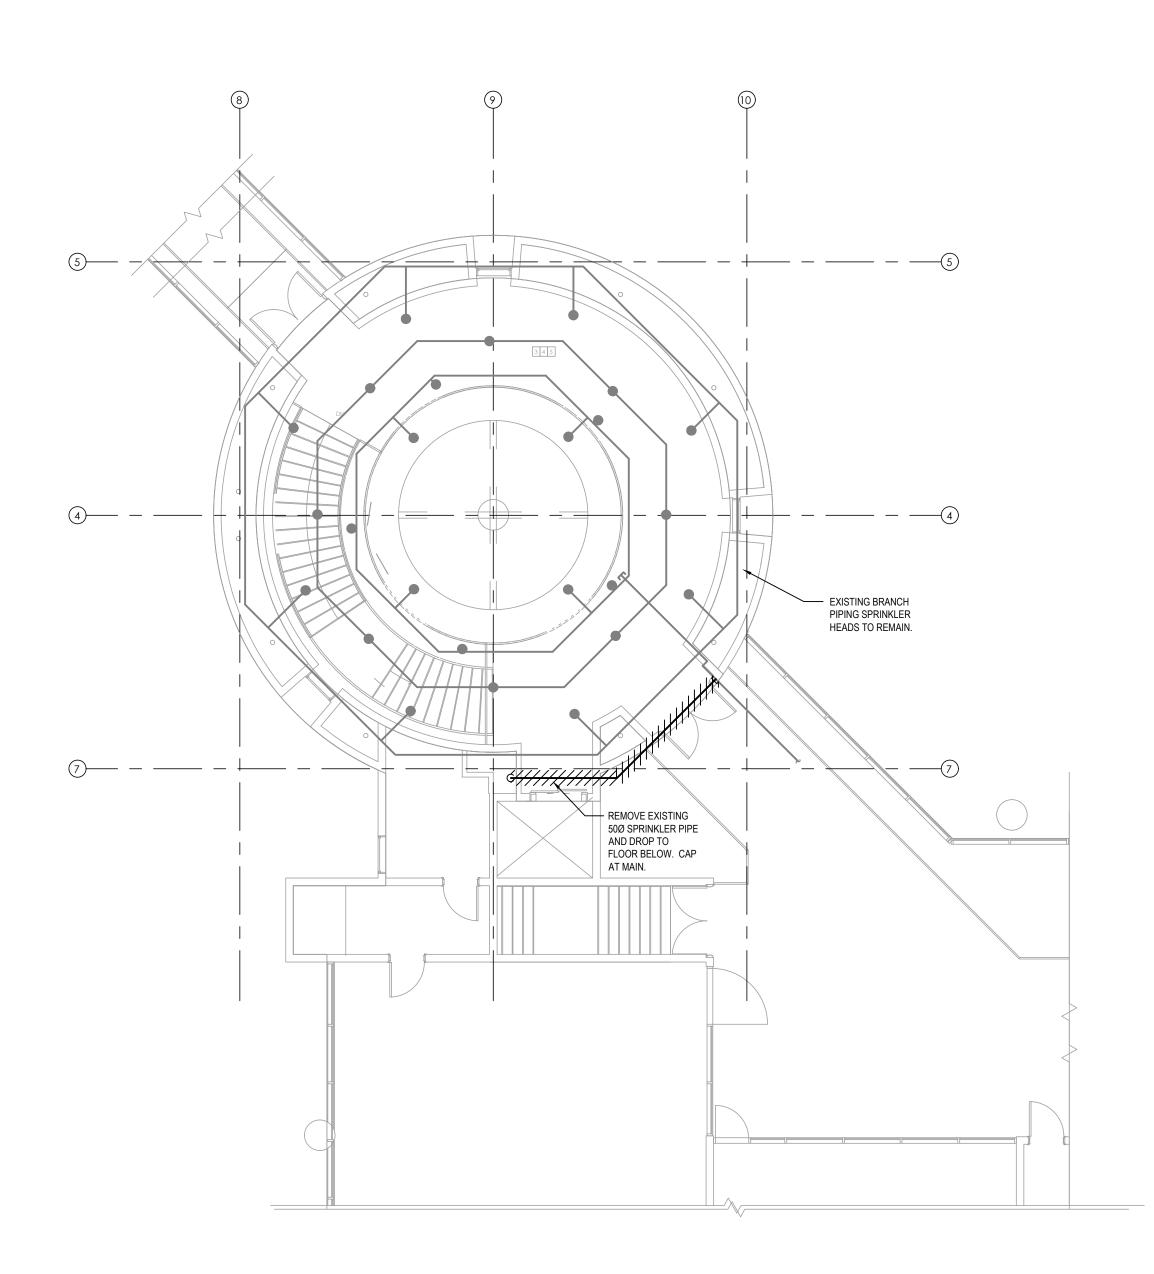







Vancouver • Langley • Victoria • Nanaimo • Kelowna • Kamloops • Nelson • Smithers MECHANICAL CONSULTING ENGINEERS Tel: (778) 471-6472 Kamloops Office 202-1339 McGill Road Kamloops, BC V2C 6K7



 This drawing is the property of the Architect and unauthorized reproduction is prohibited under the Copyright Act. Electronic files when provided are instruments of service and the sole property of Sahuri + partners architecture inc. No alteration or reproduction shall be made without written authorization from Sahuri + partners architecture inc. The Contractor shall check and verify all dimensions and report any discrepancies to the Architect prior to construction; do not scale this drawing. This drawing shall not be used for construction unless properly noted as 'ISSUED FOR CONSTRUCTION' by the Architect.

All dimensions are in millimeters unless noted otherwise.

ISSUES/REVISIONS DATE DESCRIPTIO 2024-02-22 ISSUED FOR TENDER DESCRIPTION







Project Title PG TOURISM OFFICE 808 CANADA GAMES WAY, PRINCE GEORGE

Drawing Title MAIN & SECOND FLOOR FIRE PROTECTION DEMOLITION PLAN

 Drawing info
 Project Number


 Scale
 1:100


 Date
 2023-12-21


 Drawn
 CL

 Checked
 CL


 Partner
 CL

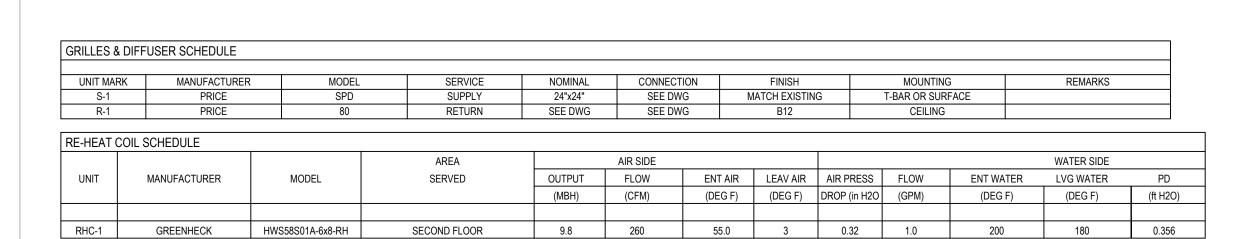

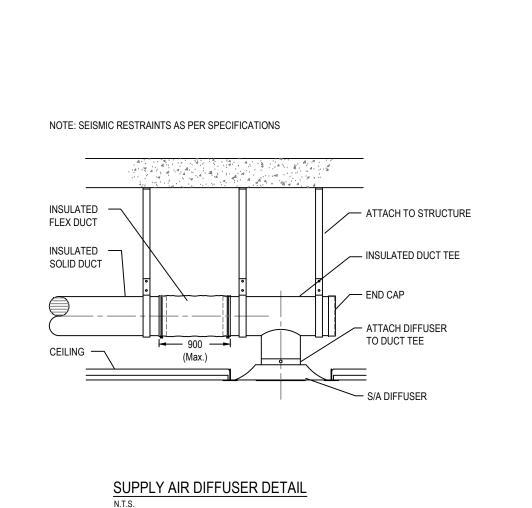


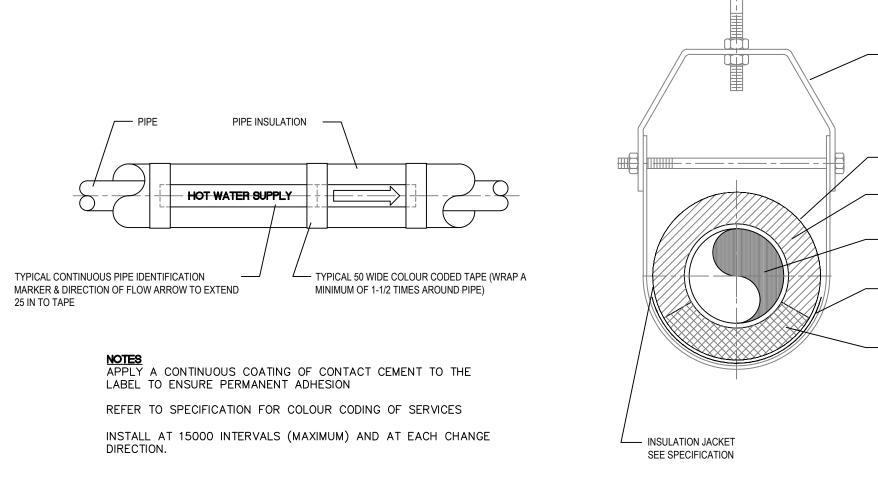


PIPE IDENTIFICATION DETAIL

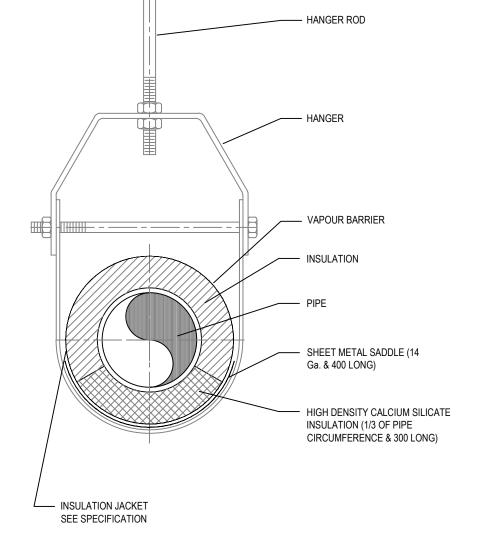

INSULATED PIPE HANGER DETAIL

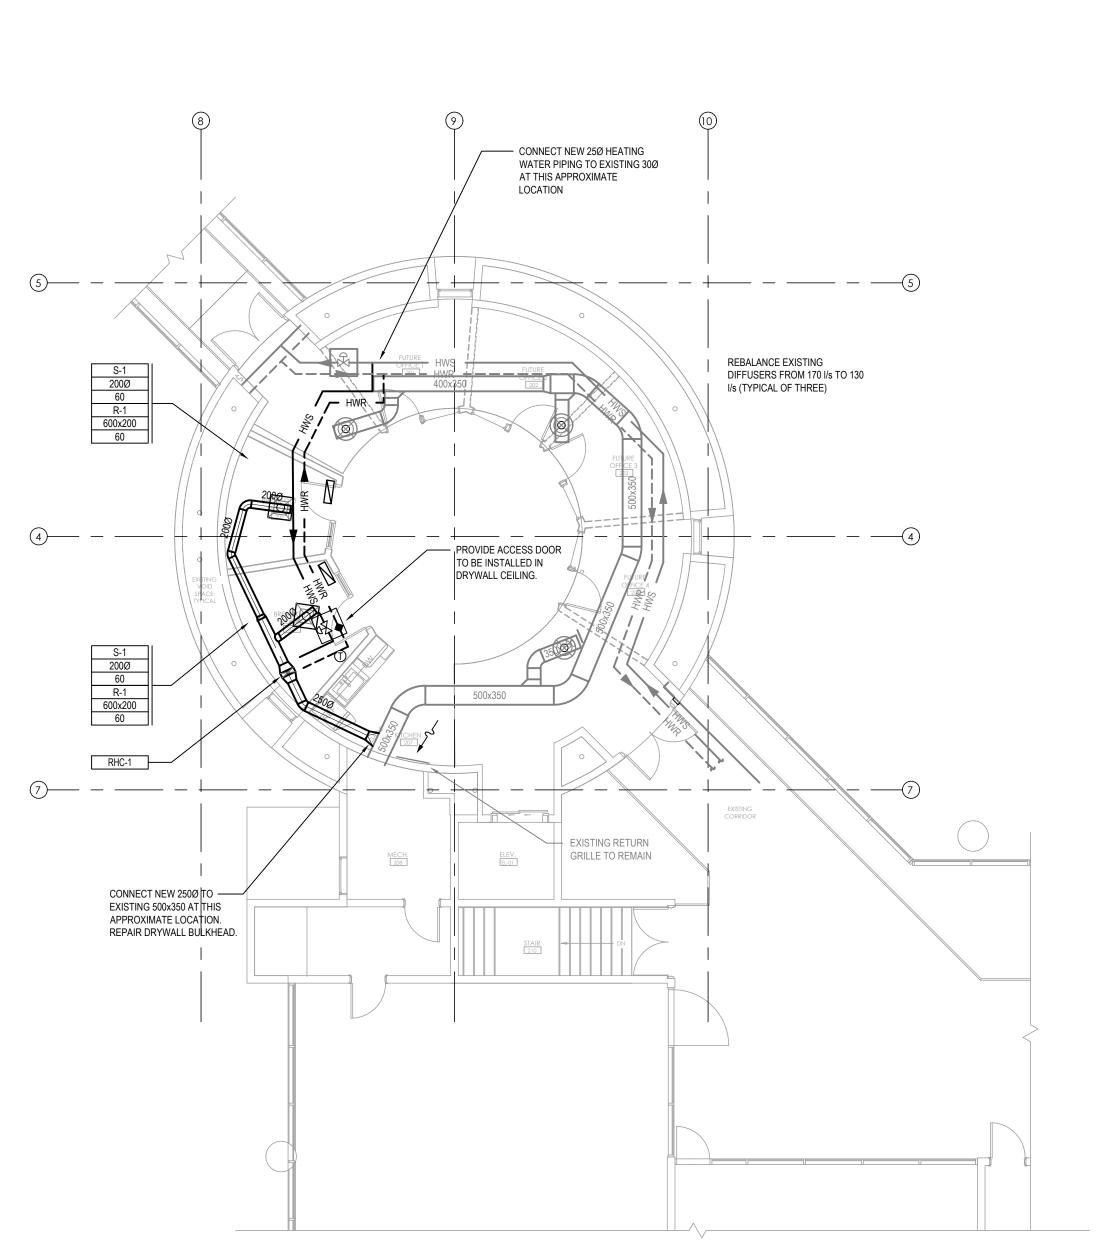

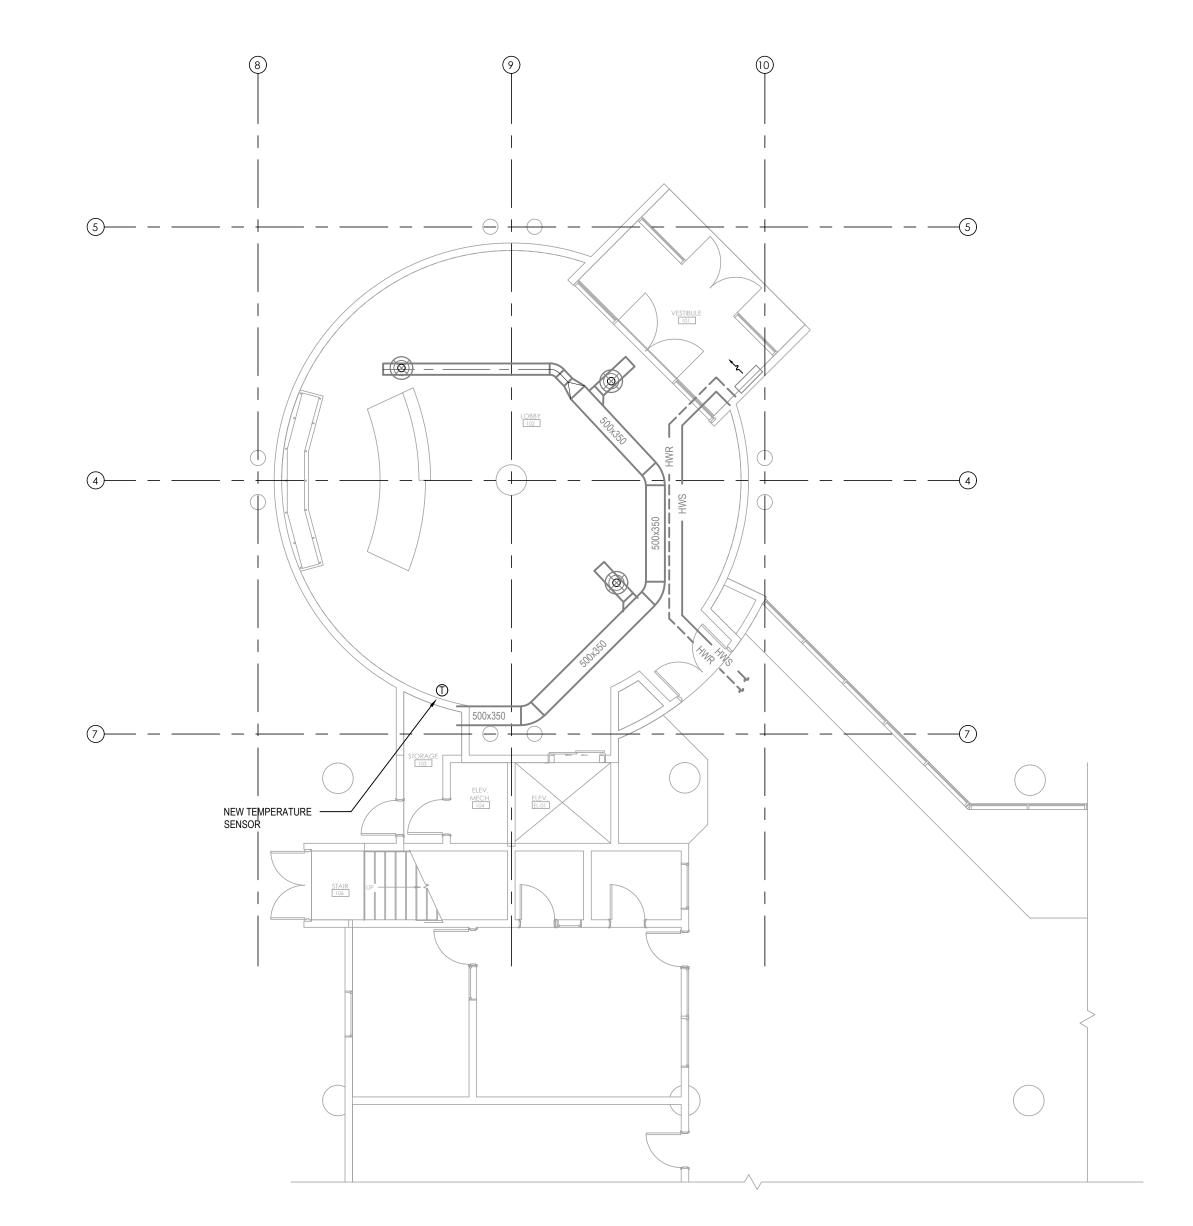





This drawing is the property of the Architect and unauthorized reproduction is prohibited under the Copyright Act. Electronic files when provided are instruments of service and the sole property of Sahuri + partners architecture inc. No alteration or reproduction shall be made without written authorization from Sahuri + partners architecture inc. The Contractor shall check and verify all dimensions and report any discrepancies to the Architect prior to construction; do not scale this drawing. This drawing shall not be used for construction unless properly noted as 'ISSUED FOR CONSTRUCTION' by the Architect. All dimensions are in millimeters unless noted otherwise. ISSUES/REVISIONS DESCRIPTION 2024-02-22 ISSUED FOR TENDER

Vancouver • Langley • Victoria • Nanaimo • Kelowna • Kamloops • Nelson • Smithers

Tel: (778) 471-6472


MECHANICAL CONSULTING ENGINEERS

Kamloops Office

202-1339 McGill Road Kamloops, BC V2C 6K7

TRUE

NORTH

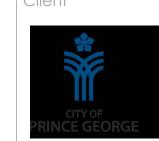





Project Title PG TOURISM OFFICE 808 CANADA GAMES WAY, PRINCE GEORGE

Drawing Title MAIN & SECOND FLOOR HVAC PLAN

Drawing	info	Project Numb
Scale	1:100	2
Date	2023-12-21	Drawing Numb
Drawn	CL	1 100
Checked	CL	NA'2(

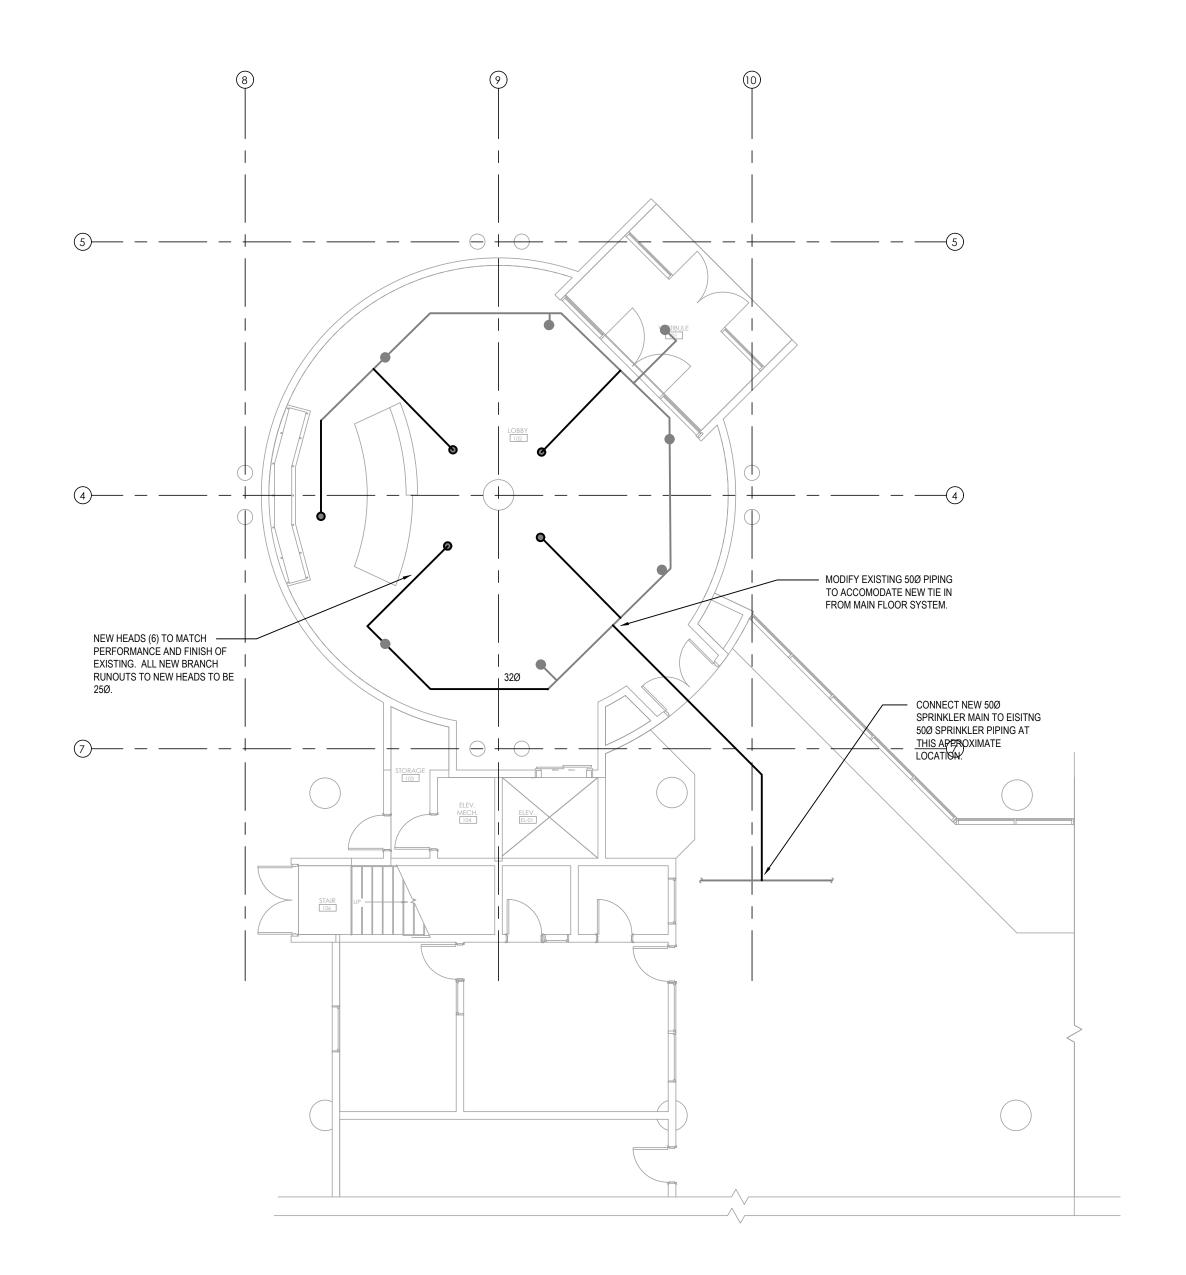


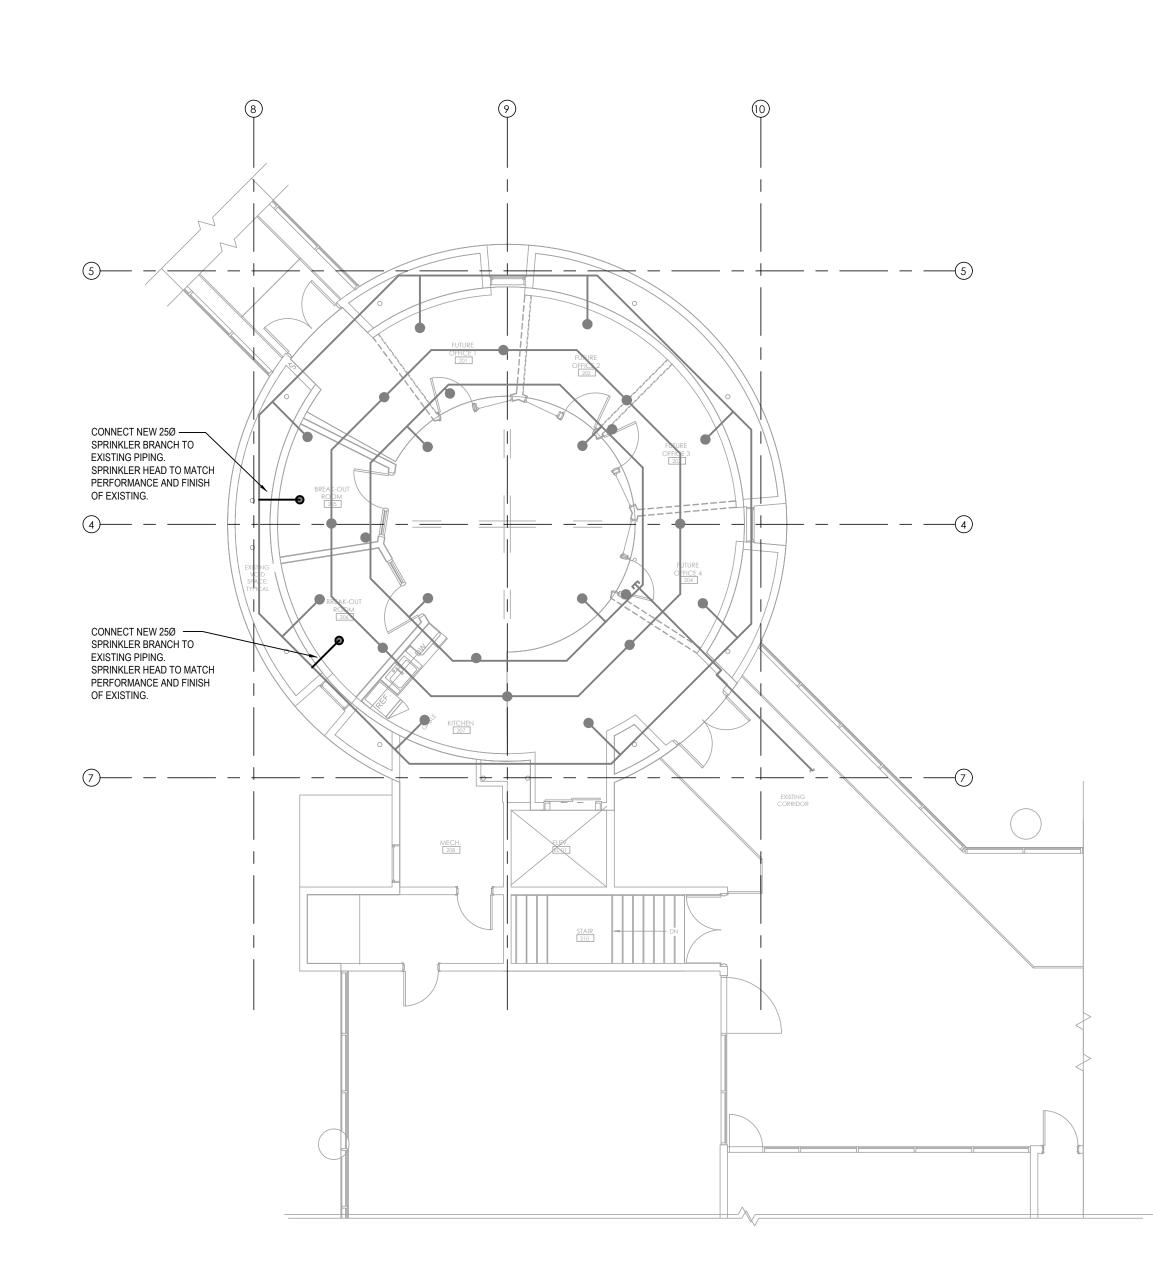





Vancouver • Langley • Victoria • Nanaimo • Kelowna • Kamloops • Nelson • Smithers MECHANICAL CONSULTING ENGINEERS Tel: (778) 471-6472 Kamloops Office 202-1339 McGill Road Kamloops, BC V2C 6K7

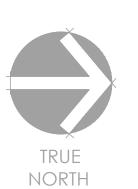

 This drawing is the property of the Architect and unauthorized reproduction is prohibited under the Copyright Act. Electronic files when provided are instruments of service and the sole property of Sahuri + partners architecture inc. No alteration or reproduction shall be made without written authorization from Sahuri + partners architecture inc. The Contractor shall check and verify all dimensions and report any discrepancies to the Architect prior to construction; do not scale this drawing. This drawing shall not be used for construction unless properly

noted as 'ISSUED FOR CONSTRUCTION' by the Architect. All dimensions are in millimeters unless noted otherwise.

ISSUES/REVISIONS DESCRIPTION 2024-02-22 ISSUED FOR TENDER







Project Title PG TOURISM OFFICE 808 CANADA GAMES WAY, PRINCE GEORGE

Drawing Title MAIN & SECOND FLOOR FIRE PROTECTION RENOVATION PLAN

Drawing info Project Number
Scale 1:100 24030-T

Date 2023-12-21 Drawing Number CL Checked CL Partner CL